


- LEGEND**
- BASIN
 - PEDESTAL WATER CLOSET
 - URINAL CLOSET
 - SHOWER

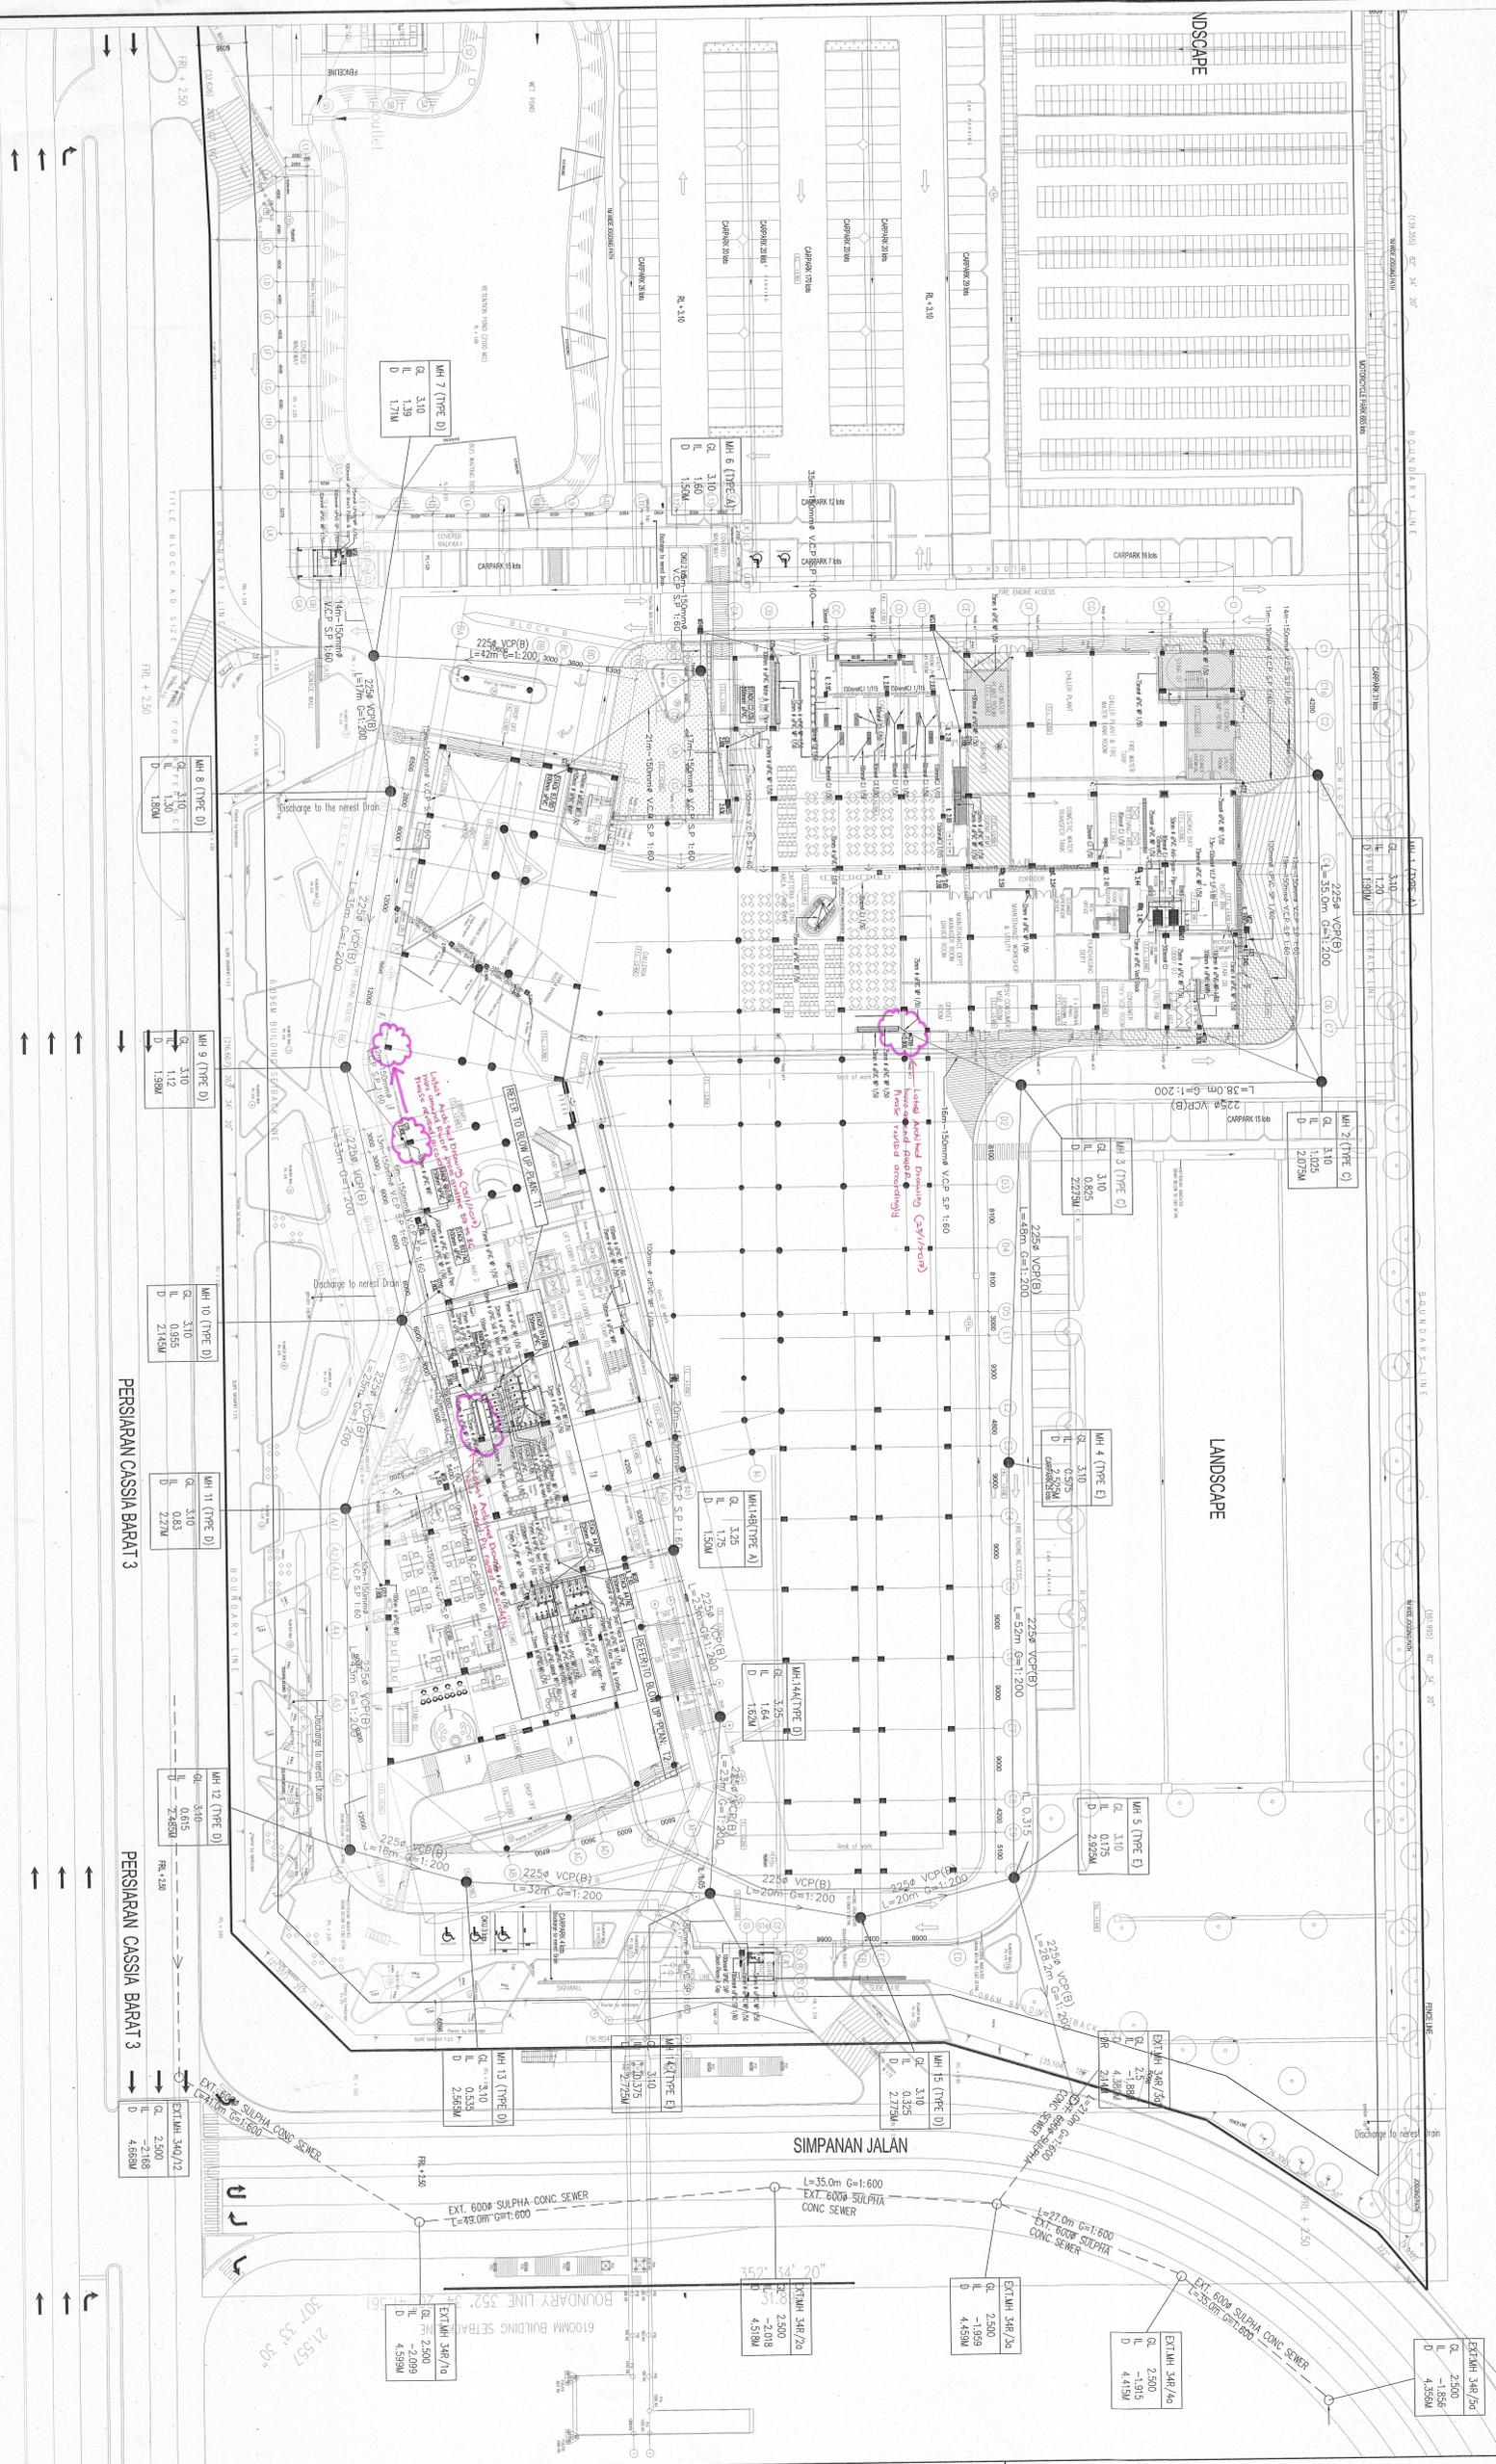

SHOP DRAWING

TITLE SHEET

PROJECT TITLE

PROJECT DESCRIPTION

DATE

SCALE/S

REVISION

PERUNDING KEJANA CIVIL & STRUCTURAL ENGINEERS

T&T PUMBINING AND SANITARY

Engineer's Signature

GROUND FLOOR PLAN

Drawing Title


Project Title

Project Description

DATE


SCALE/S

REVISION

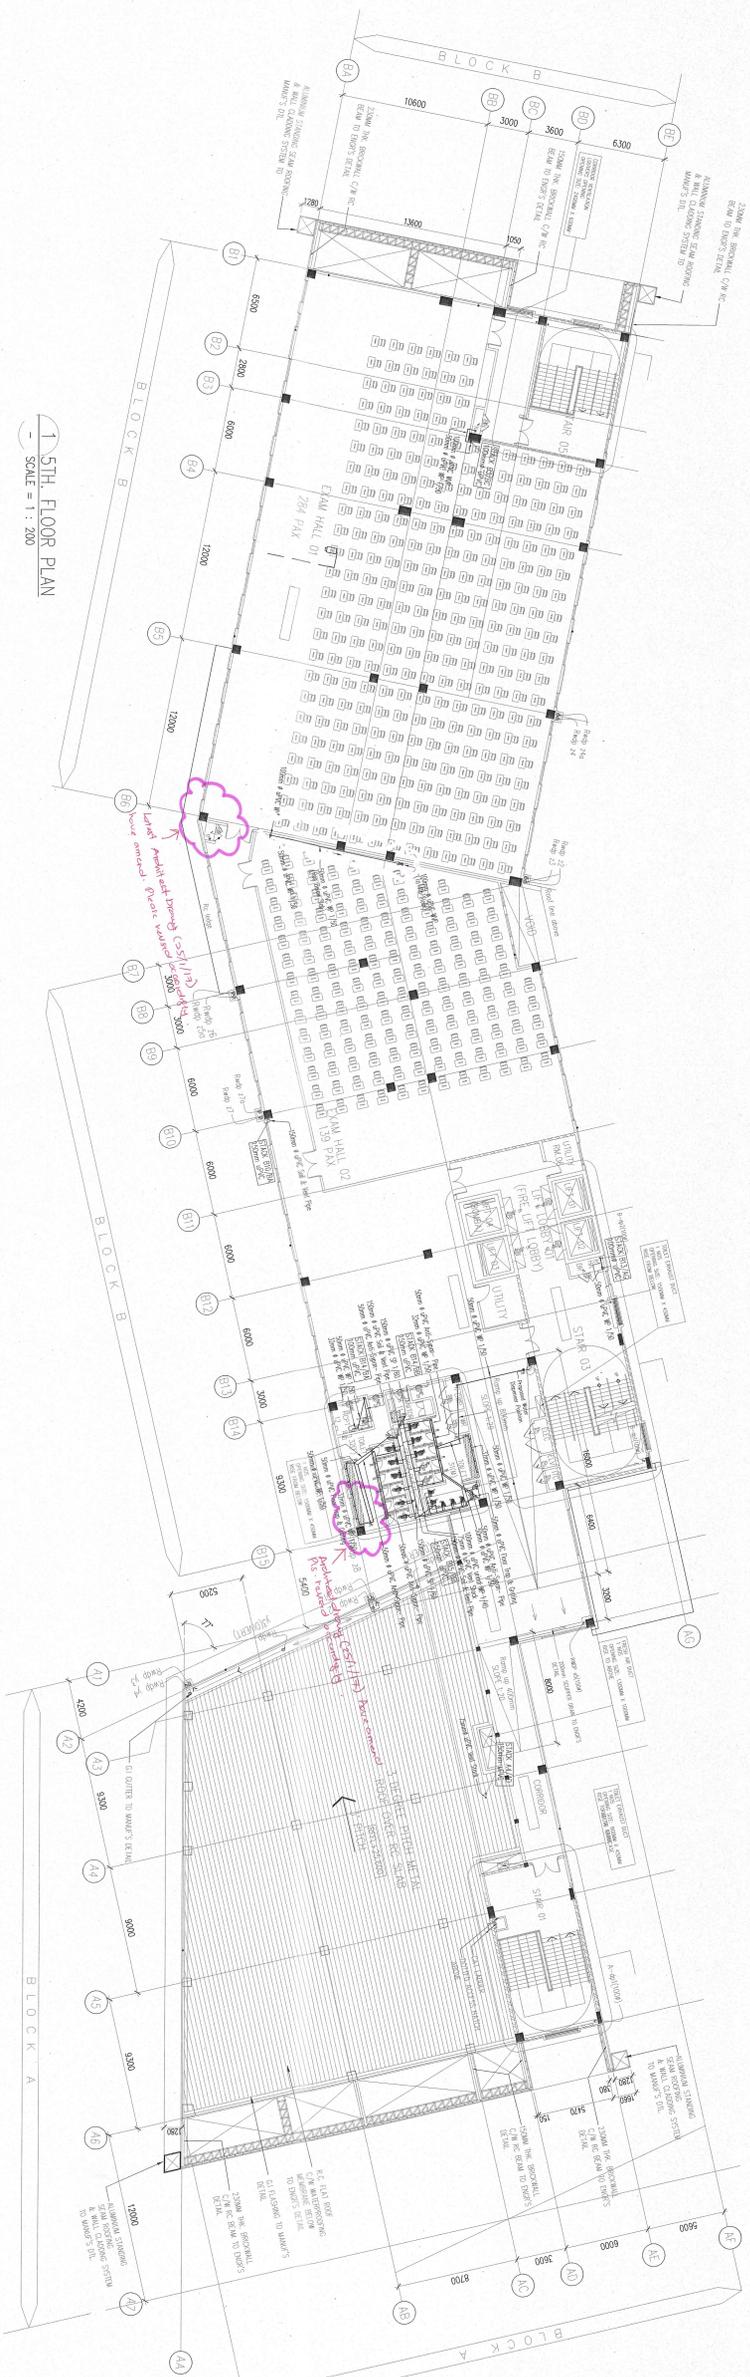

1 5TH FLOOR PLAN
SCALE = 1 : 200

5TH FLOOR PLAN

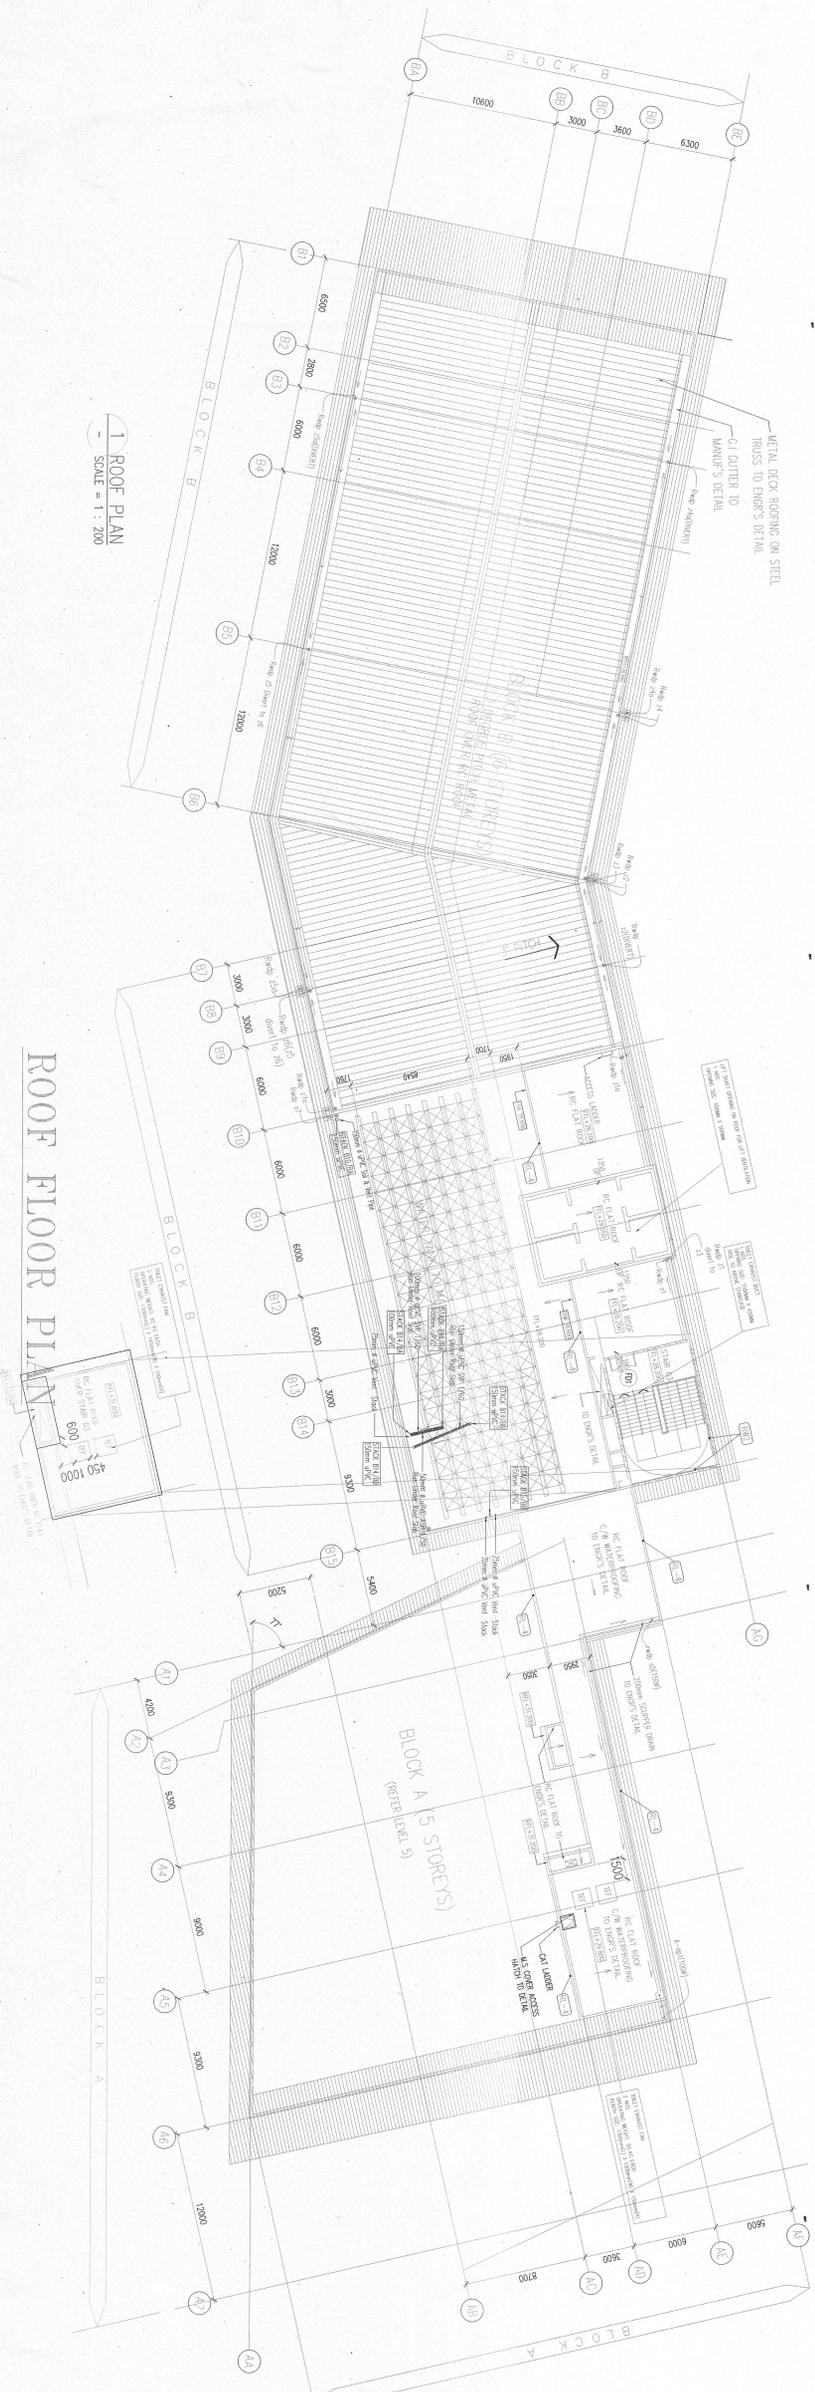

1 ROOF PLAN
SCALE = 1 : 200

ROOF FLOOR PLAN

Project Title
**CABANGAN PEMASANGAN PAIP AIR -
 BAGI CABANGAN MEMBINA SEBUAH KOLEJ
 UNIVERSITI SWASTA YANG MENGANDUNGI:
 BLOCK A - PUSAT PENYIARAN 5 TINGKAT
 BLOCK B - BERISTIAKAN DAN BUKU
 KULIAH 6 TINGKAT
 BLOCK C - BANGUNAN AKADMIK DAN
 DEWAN SERBAGUNA 3 TINGKAT
 BLOCK D - BANGUNAN AKADMIK 5
 TINGKAT
 BLOCK E - BANGUNAN AKADMIK 5
 TINGKAT
 2 UNIT PONDOK PENGAJANG
 1 UNIT NIB 11 KV STESEN SUKSES UTAMA
 DI ATAS PT 8828, WUKAM 13, SEBERANG
 PERAI SELATAN, PULAU PINANG
 UNLTK -
 TELUKAN KOU COLLEGE (PK) SIONGHO.**


Approved Building Plan No.
 Drawing Title
GROUND FLOOR PLAN

Tandatangan Penyaji
 Nama: DR. CHONG BENG HOCK (KUALA PERUMBA EKSEKUTIF)
 Alamat: 1501, Jalan Teluk Anson, 11500, Teluk Anson, Pulau Pinang
 No. Tel: 04-626-0000
 Faks: 04-626-0000
 E-mel: chongbeng@pk.com.my

Penyaji:
**T&T PLUMBING AND
 SANITARY**
 38, Lintang Bayan Sisa 4,
 Taman Bayan Sisa,
 Bayan Lepas, Pulau Pinang.
 Tel: 04-6601511 Fax: 04-6601513
 E-mel: tt@pk.com.my

Designer's Signature
 TIME DRAWING
SANITARY - 5TH & ROOF PLAN
 SHOP DRAWING
 DATE: JAN 2017 CHECKED: R. LAI
 SCALE/S: 1 : 75 PREPARED: HIRAN
 18/10/2016/016 REVISION: 0

PK PERUMBA KUALA PERUMBA
 Level 12, Tower 13/10, Wisma Perumba Siam,
 No. 1, Penang Road,
 Penang 100002, Penang, Malaysia
 Tel: 04-626-0000 Fax: 04-626-0000

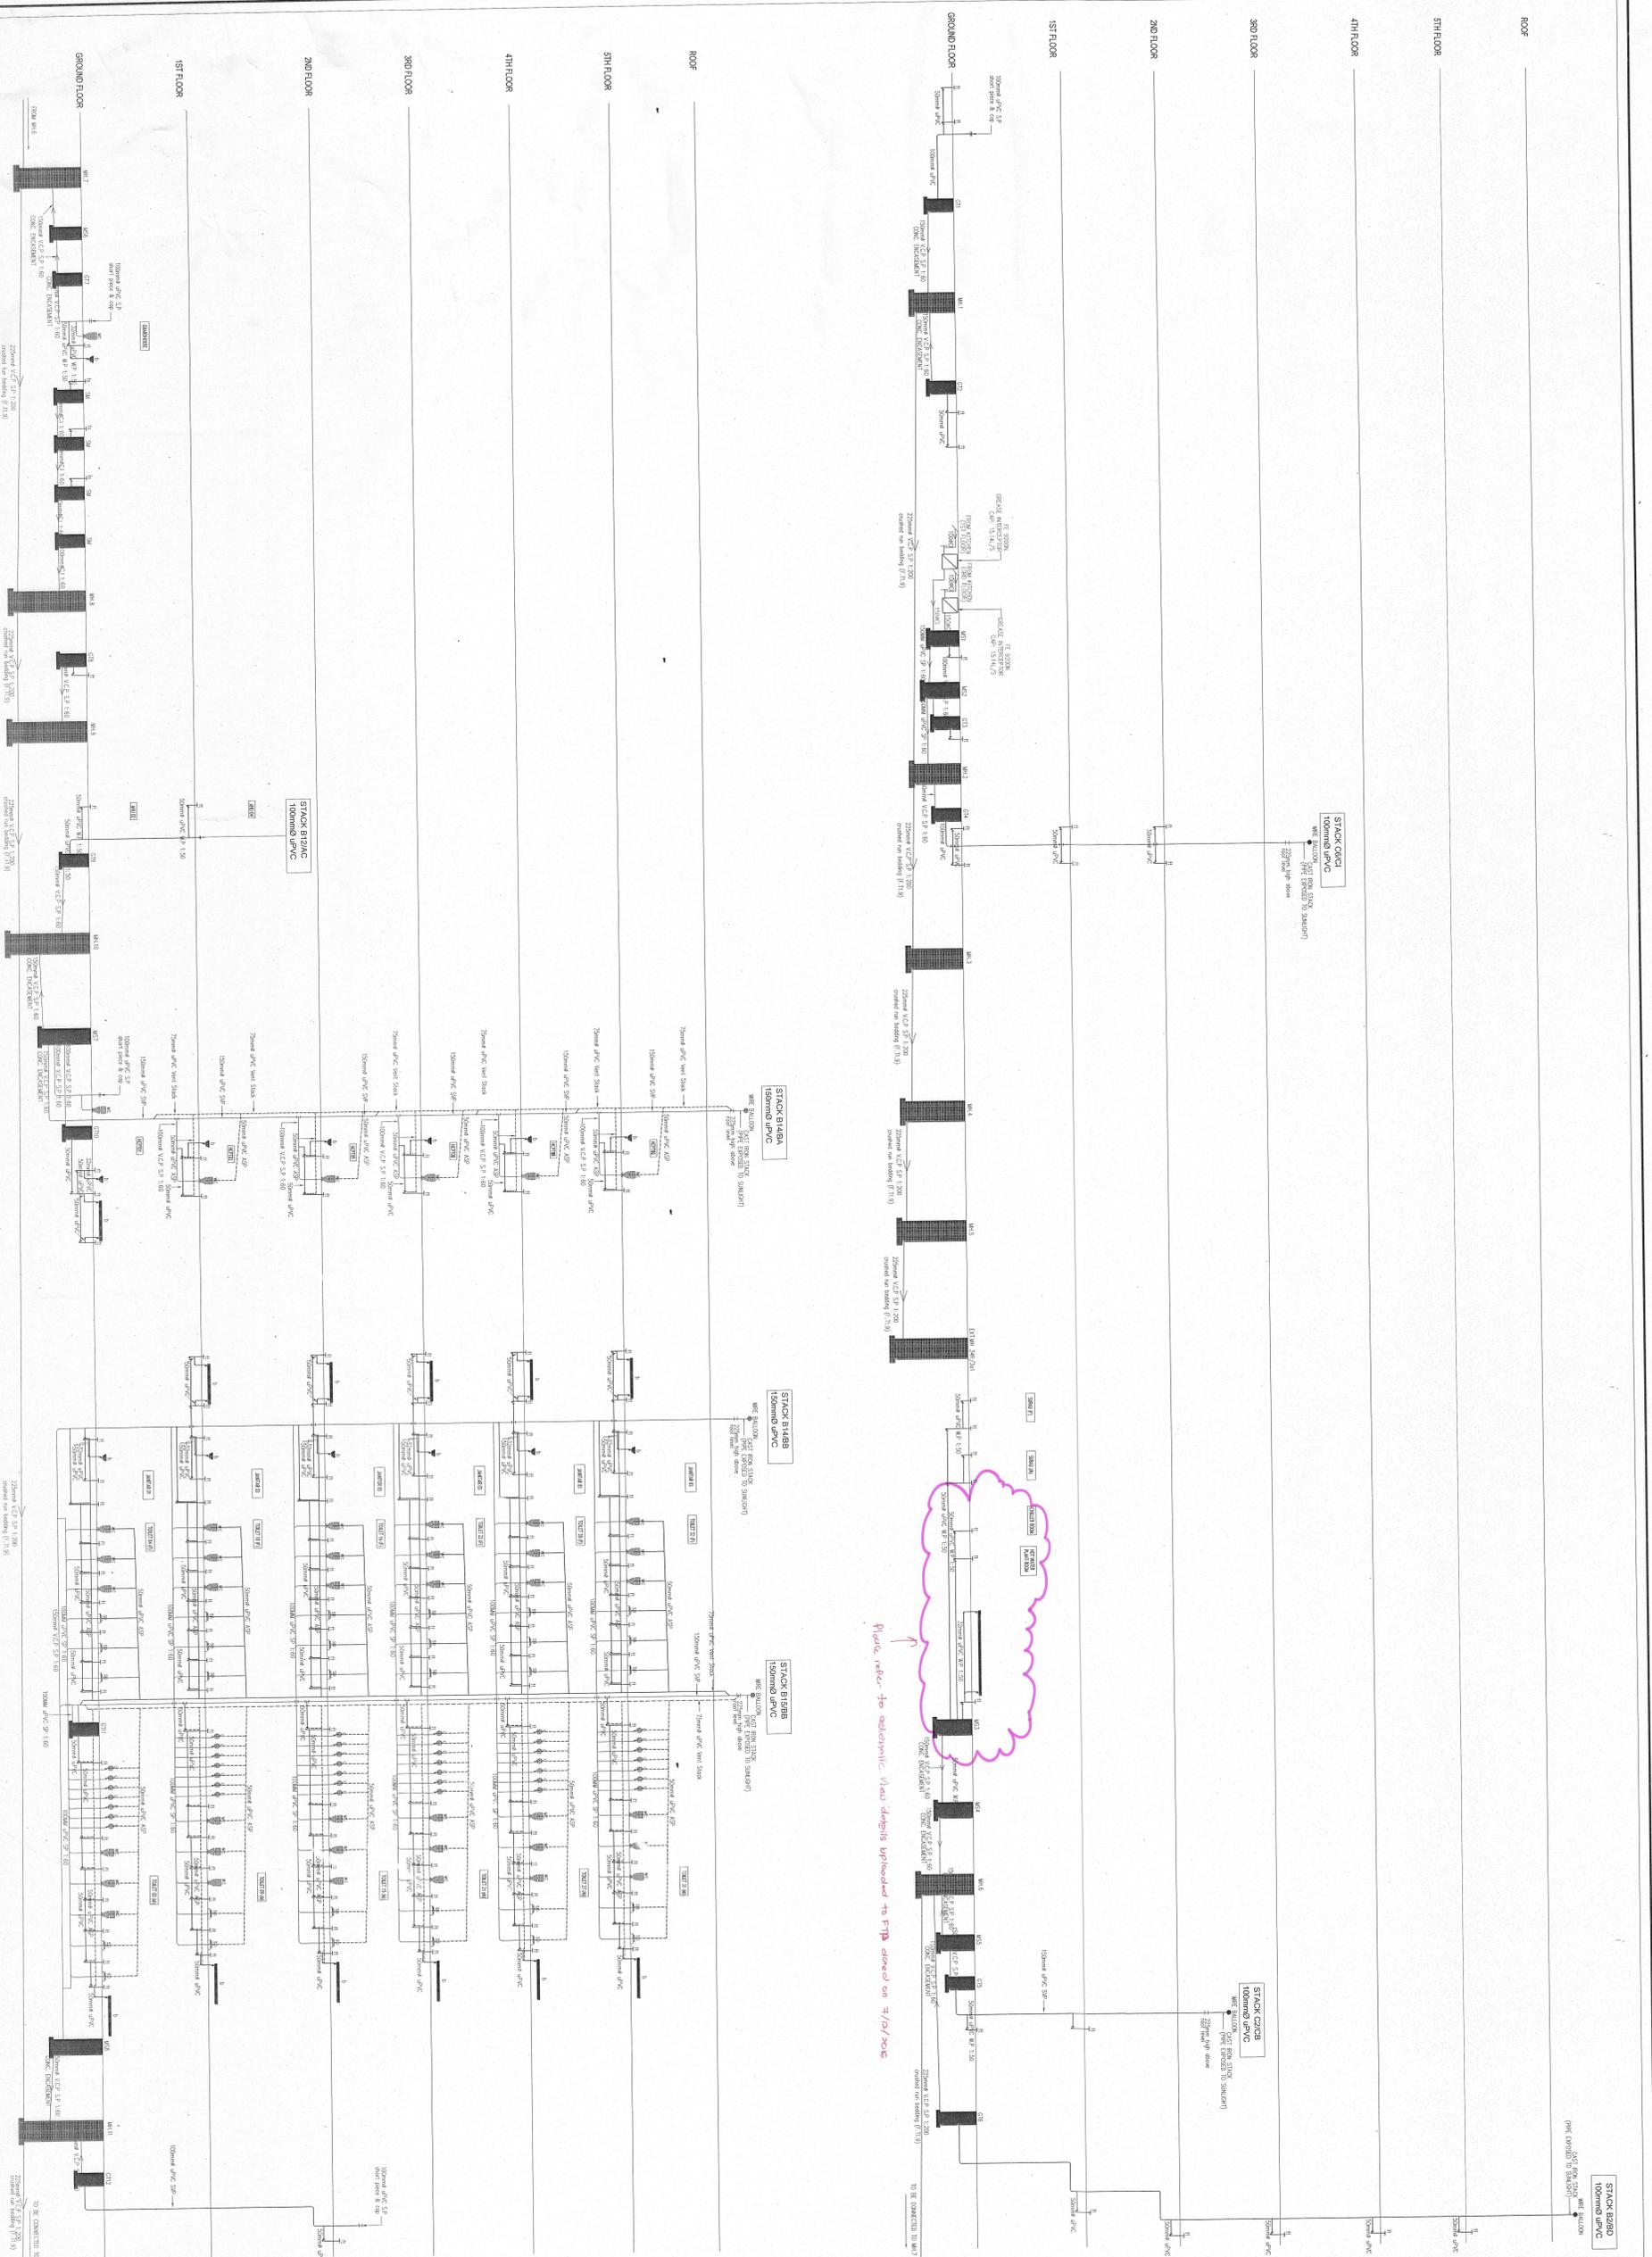

SCHEMATIC VIEW
(SCALE 1:150)

<p>Project Title CADANGAN PEMASANGAN PAIP AIR- BAGI CADANGAN MAMBIWA SEBILAH KOLEJ UNIVERSITI SWASTA YANG MENGGUNAKAN: BLOCK A - PUSAT PENYATAAN 5 LINGKAT BLOCK B - PERPUSTAKAAN DAN BUKU KILAH 6 LINGKAT BLOCK C - BANJIRAN AKADEMIK DAN DEWAN SERBAGUNA 3 LINGKAT BLOCK D - DEWAN KALAH DAN /METERIA BLOCK E - BANJIRAN AKADEMIK 5 LINGKAT 2 UNIT PONDOK PENGAJAL 1 UNIT TMB 11 KV STESEN SUSU JAWA DI ATAS PT 5828, MUKAM 13, SEBERANG PERAI SELATAN, PULAU PINANG</p>		<p>Drinking Title GROUND FLOOR PLAN</p>	
<p>Approval Building Plan No. ITUVAN KBU COLEGE (P2) S/MBHD</p>		<p>Engineer's Signature T&T PUMBINING ANJ SANITARY 38, Lorong Selegie Street 4, Tingkat Atas, No. 11, Block 111, The Arcade, 10100 Penang, Malaysia Email: t.pumbin@pkpk.com</p>	
<p>PK PERUNDING KELANA CIVIL & STRUCTURAL ENGINEERS No. 11, Block 111, The Arcade, 10100 Penang, Malaysia Tel: 04-2610000, Fax: 9641010</p>		<p>SHOP DRAWING SCHEMATIC VIEW - 1</p>	
<p>DATE JAN 2017</p>	<p>CHECKED R. LAI</p>	<p>SCALE/S 1: 150</p>	<p>PREPARED HILMAN</p>
<p>REVISION 0</p>	<p>REVISION 0</p>	<p>REVISION 0</p>	<p>REVISION 0</p>