



00 LEVEL 1-KEY PLAN
710-01 SCALE = N.T.S

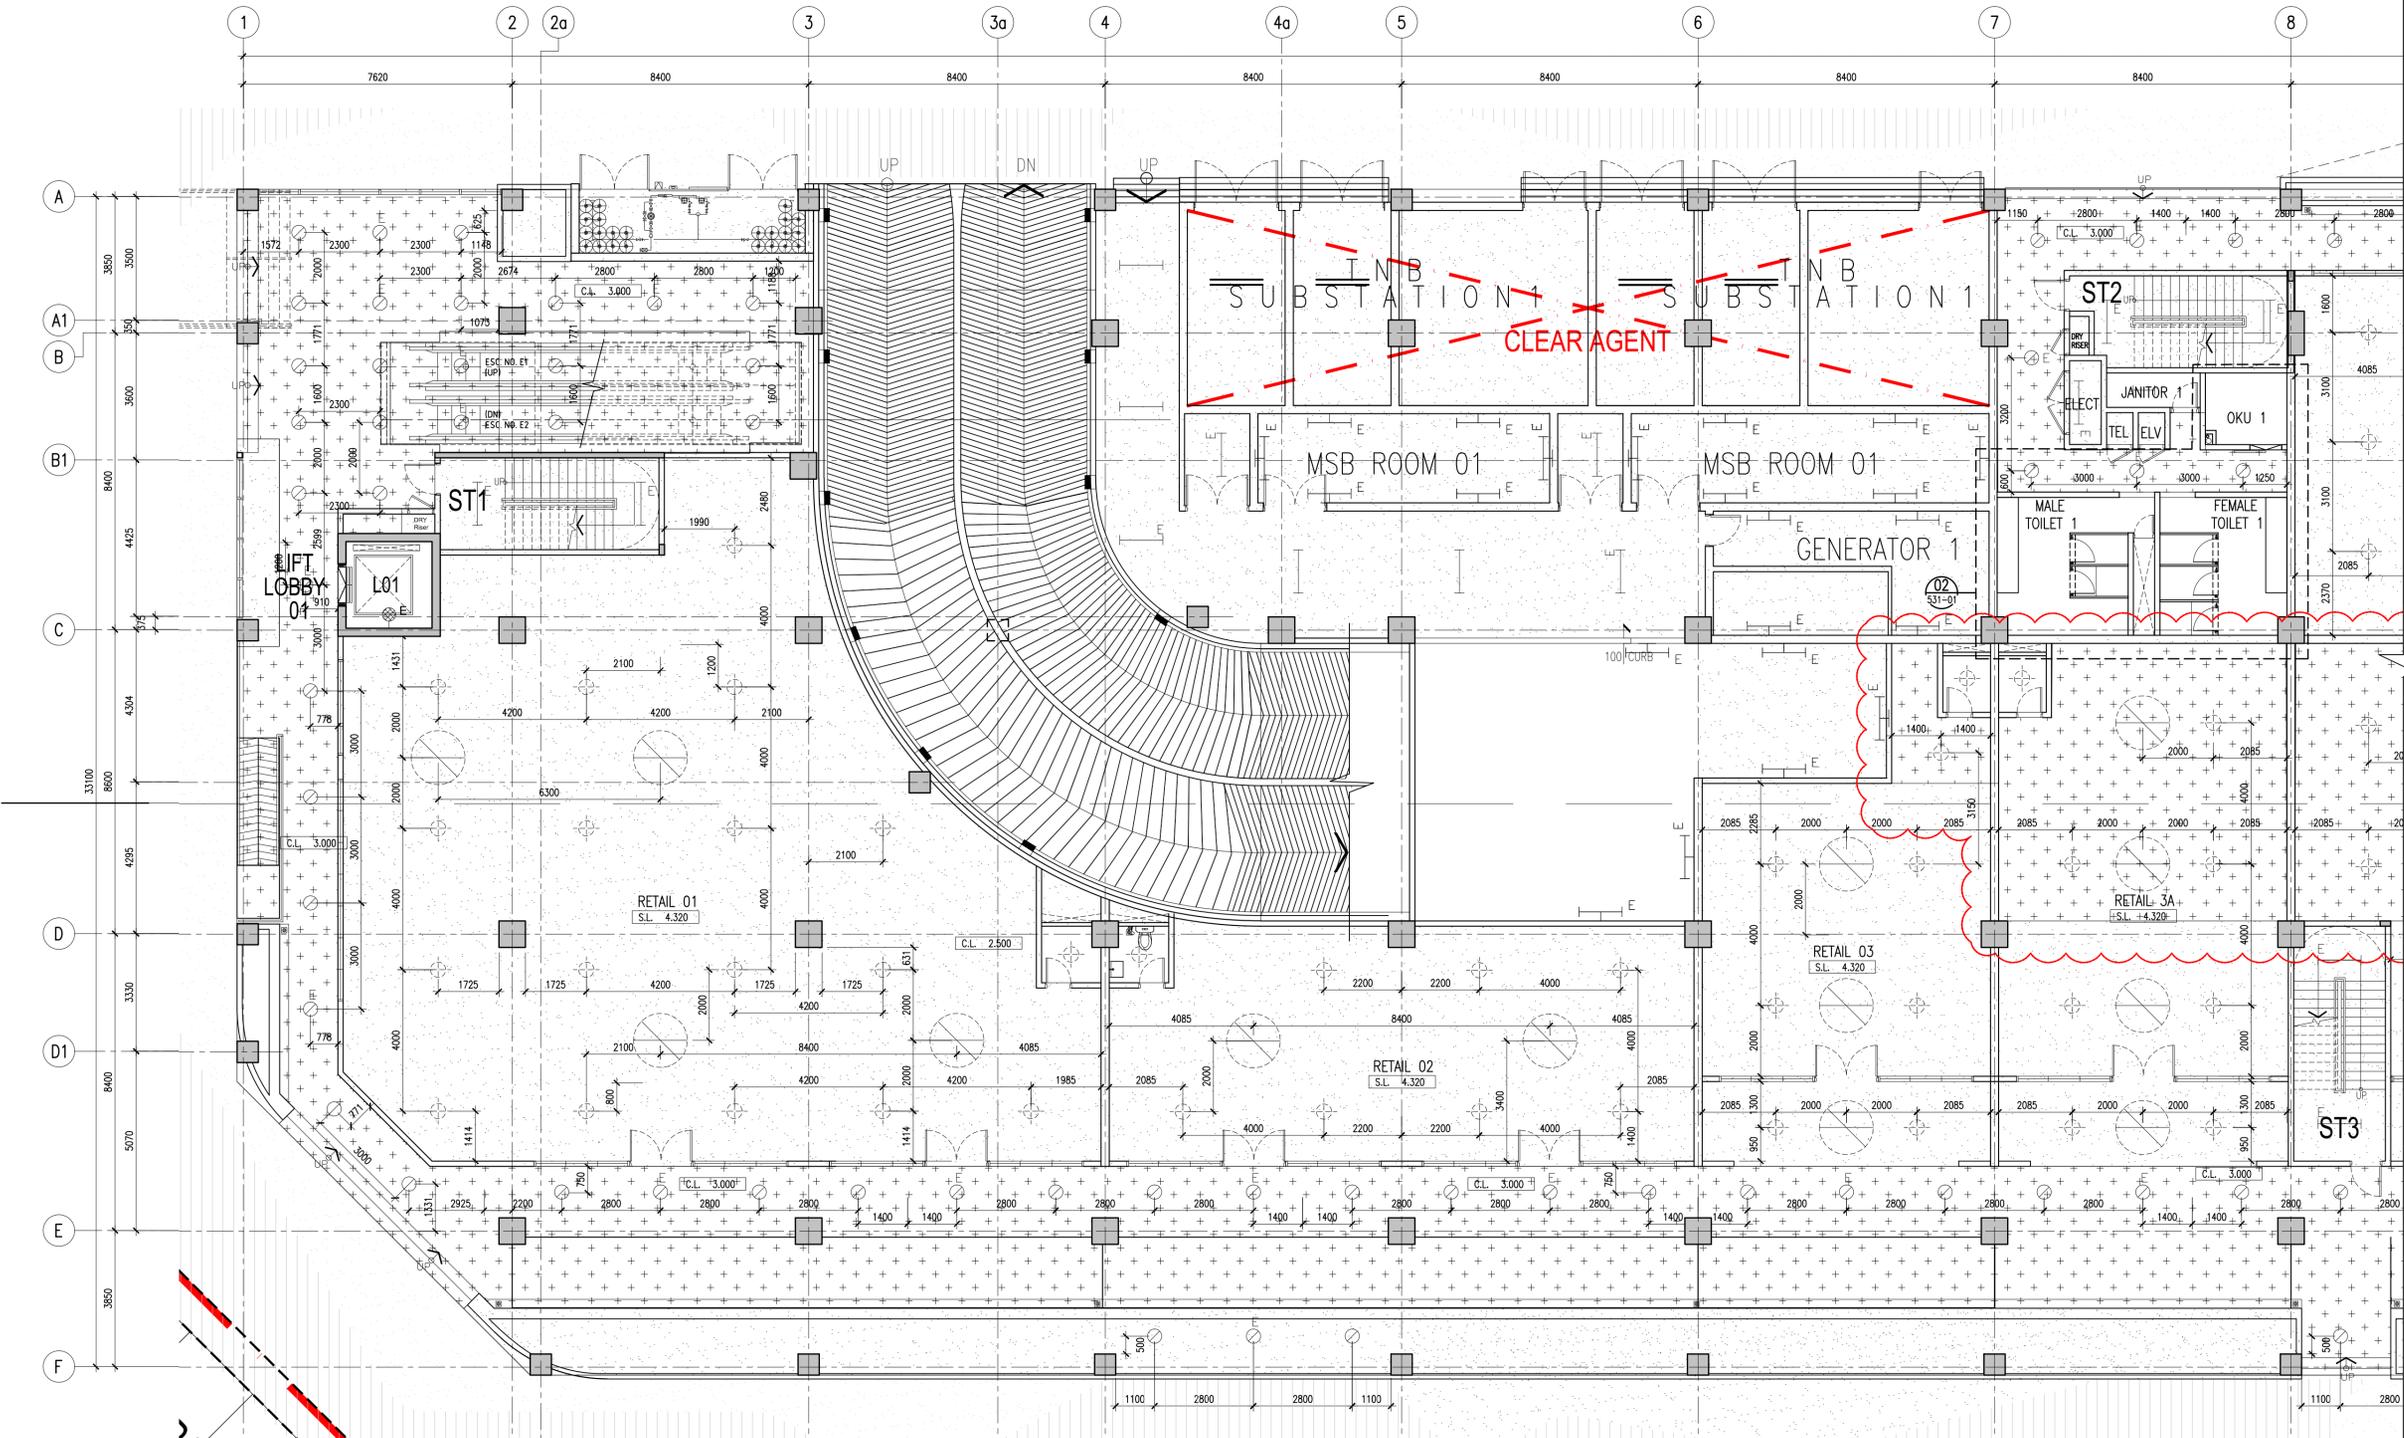

01 LEVEL 1 (DETAIL PLAN 1)
711-01 SCALE = 1 : 100

Hak Cipta Terpelihara. Tidak dibenarkan mencetak mana-mana bahagian ilustrasi dalam apa jua bentuk dan dengan apa cara pun samada secara elektronik, mekanik, rakaman atau cara lain sebelum mendapat kebenaran bertulis dari BH YEW ARCHITECTS SDN. BHD.

REV.	DATE	DESCRIPTION	REMARK
A01	30/01/2018	REVISED CEILING HEIGHT	
	04/09/2018	UPDATING DRAWING	abdul rahim

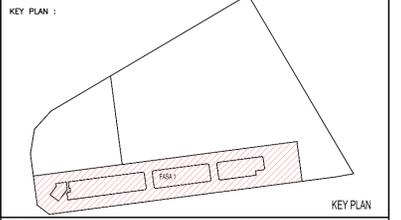

PROJECT TITLE :
CADANGAN MEMBINA PEMBANGUNAN BERCAKUP DI ATAS LOT 21135, PERSIARAN CASSIA BARAT 3, MUKIM 13, SEBERANG PERAI SELATAN, PULAU PINANG YANG MENGANUNGI:-
FASA 1
A. 2 BLOK PANGSAPURI PERKHIDMATAN 18 TINGKAT (612 UNIT)
B. KEDAI PEJABAT 3 TINGKAT (196 UNIT)
C. 5 TINGKAT TEMPAT LETAK KENDERAAN
UNTUK : TETUAN PARAMOUNT PROPERTY (PW) SDN. BHD

LAND OWNER & BUILDING OWNER :
NAMA : MR. OOI HUN PENG
JAWATAN : KETUA PEGAUAI EKSEKUTIF
NO IC : 650619-02-5311
ALAMAT : PARAMOUNT PROPERTY (PW) SDN. BHD
WISMA PARAMOUNT, 1A (1ST FLOOR), LORONG BLM 1/1,
BANDAR LAGUNA MERBOK, 0800 SUNGAI PETANI, KEDAH
NO. TEL : 604 - 441 9191 FAX : 604 - 441 9090

KITCHEN SPECIALIST :
GS CONSULTANT :

M&E CONSULTANT :
PERUNDING P.L.A.
Consulting Mechanical & Electrical Engineers.
8-01, WISMA PANTAI, TEL. NO. : (604) 3337990
JALAN WISMA PANTAI, FAX NO. : (604) 3317337
12200 BUTTERWORTH, PENANG. E-MAIL : project@pla-group.com

C&S CONSULTANT :
PERUNDING KELANA
CIVIL & STRUCTURAL ENGINEERS
Level 12, Unit 12(D), Wisma Boon Siew,
No.1, Penang Road, 10000 Penang.
Tel: 2622628, Fax: 2641618
(Company No. AS0232772-W)

DESIGN ARCHITECT :
ARCHITECTURE GROUP - STUDIO A
CPG CONSULTANTS PTE LTD
238B, THOMSON ROAD, #12-00 TOWER B
NOVENA SQUARE, SINGAPORE 307685
TEL: +65 6357 4468 FAX: +65 6357 4469

ARCHITECT :
BH YEW ARCHITECT (SP/Y61)
15TH FLOOR, BANGUNAN AMMETUFE
NO.1, JALAN LUMUT, 50400 KUALA LUMPUR
TEL (03) 4043-1346 FAX: (03) 4043-1349
EMAIL: yhw@nrbs.com.my

CONSTRUCTION DRAWING
MARCH 2018
LUSKAN :
REFLECTED CEILING PLAN
-LEVEL 1-KEY PLAN
-LEVEL 1 (DETAIL PLAN 1)
SCALE: AS SHOWN
DRAWN BY: solleh/abdul rahim
ORIGINATOR ACRONYM: BH YEW
CND NO.: 557_CA-711-01
CHECKED BY: HAZRAL/JANICE
PROJECT NO.: 55714
DATE: MARCH 2018
DISCIPLINE: ARCH
DWG STATUS: CA
BLOCK: -
DWC NO.: 711
DWG NO.: 01
REVISION: A

Note : M&E power points setting out to refer to M&E detail drawing